
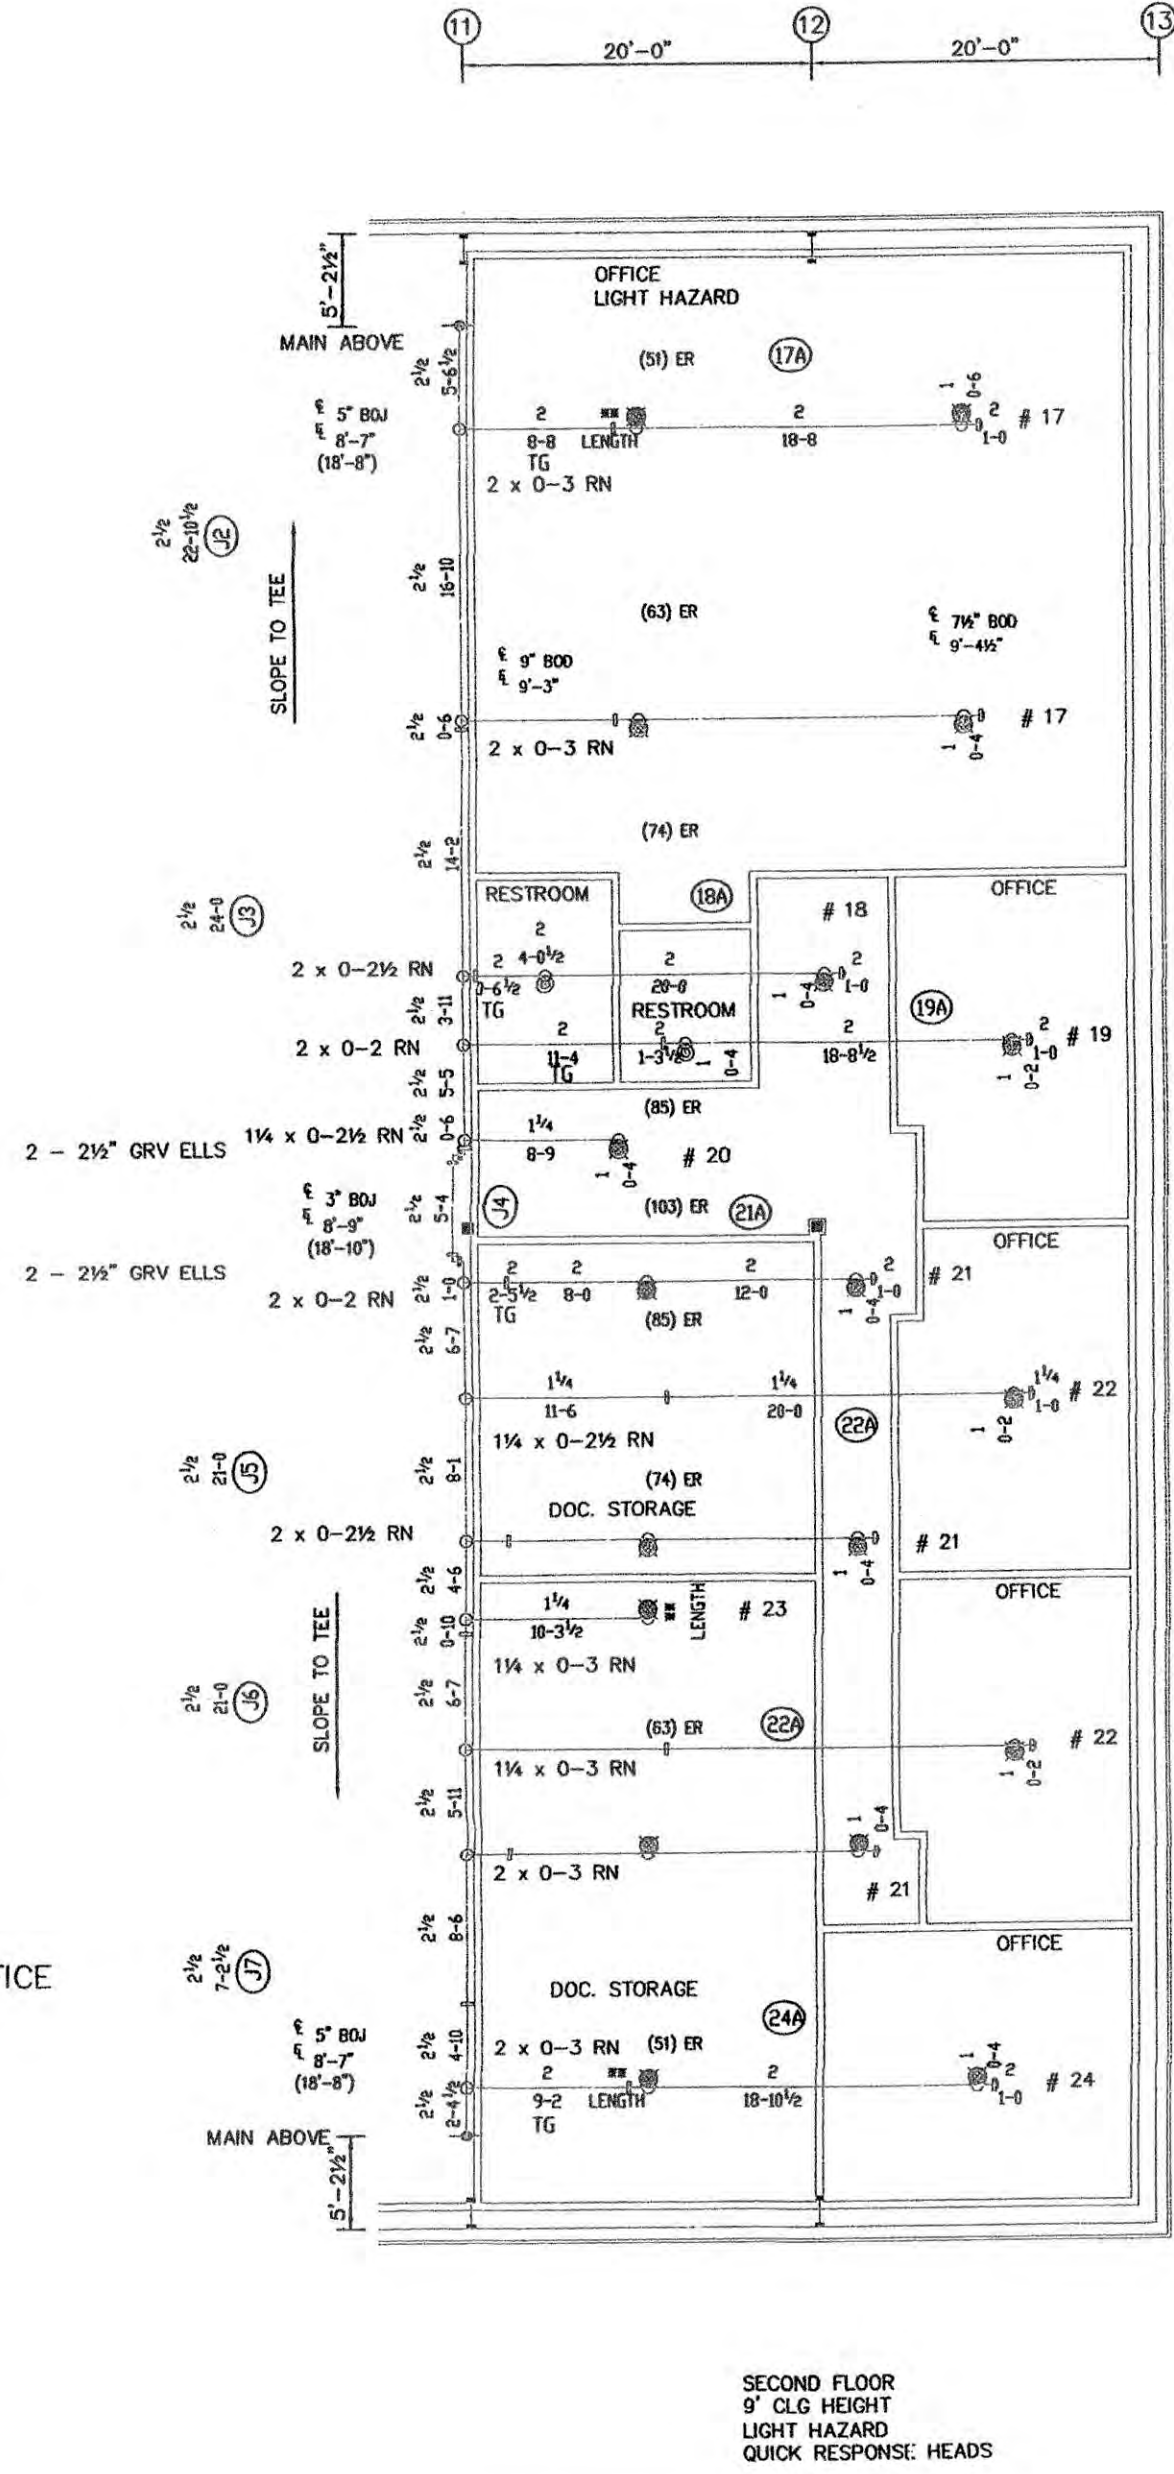
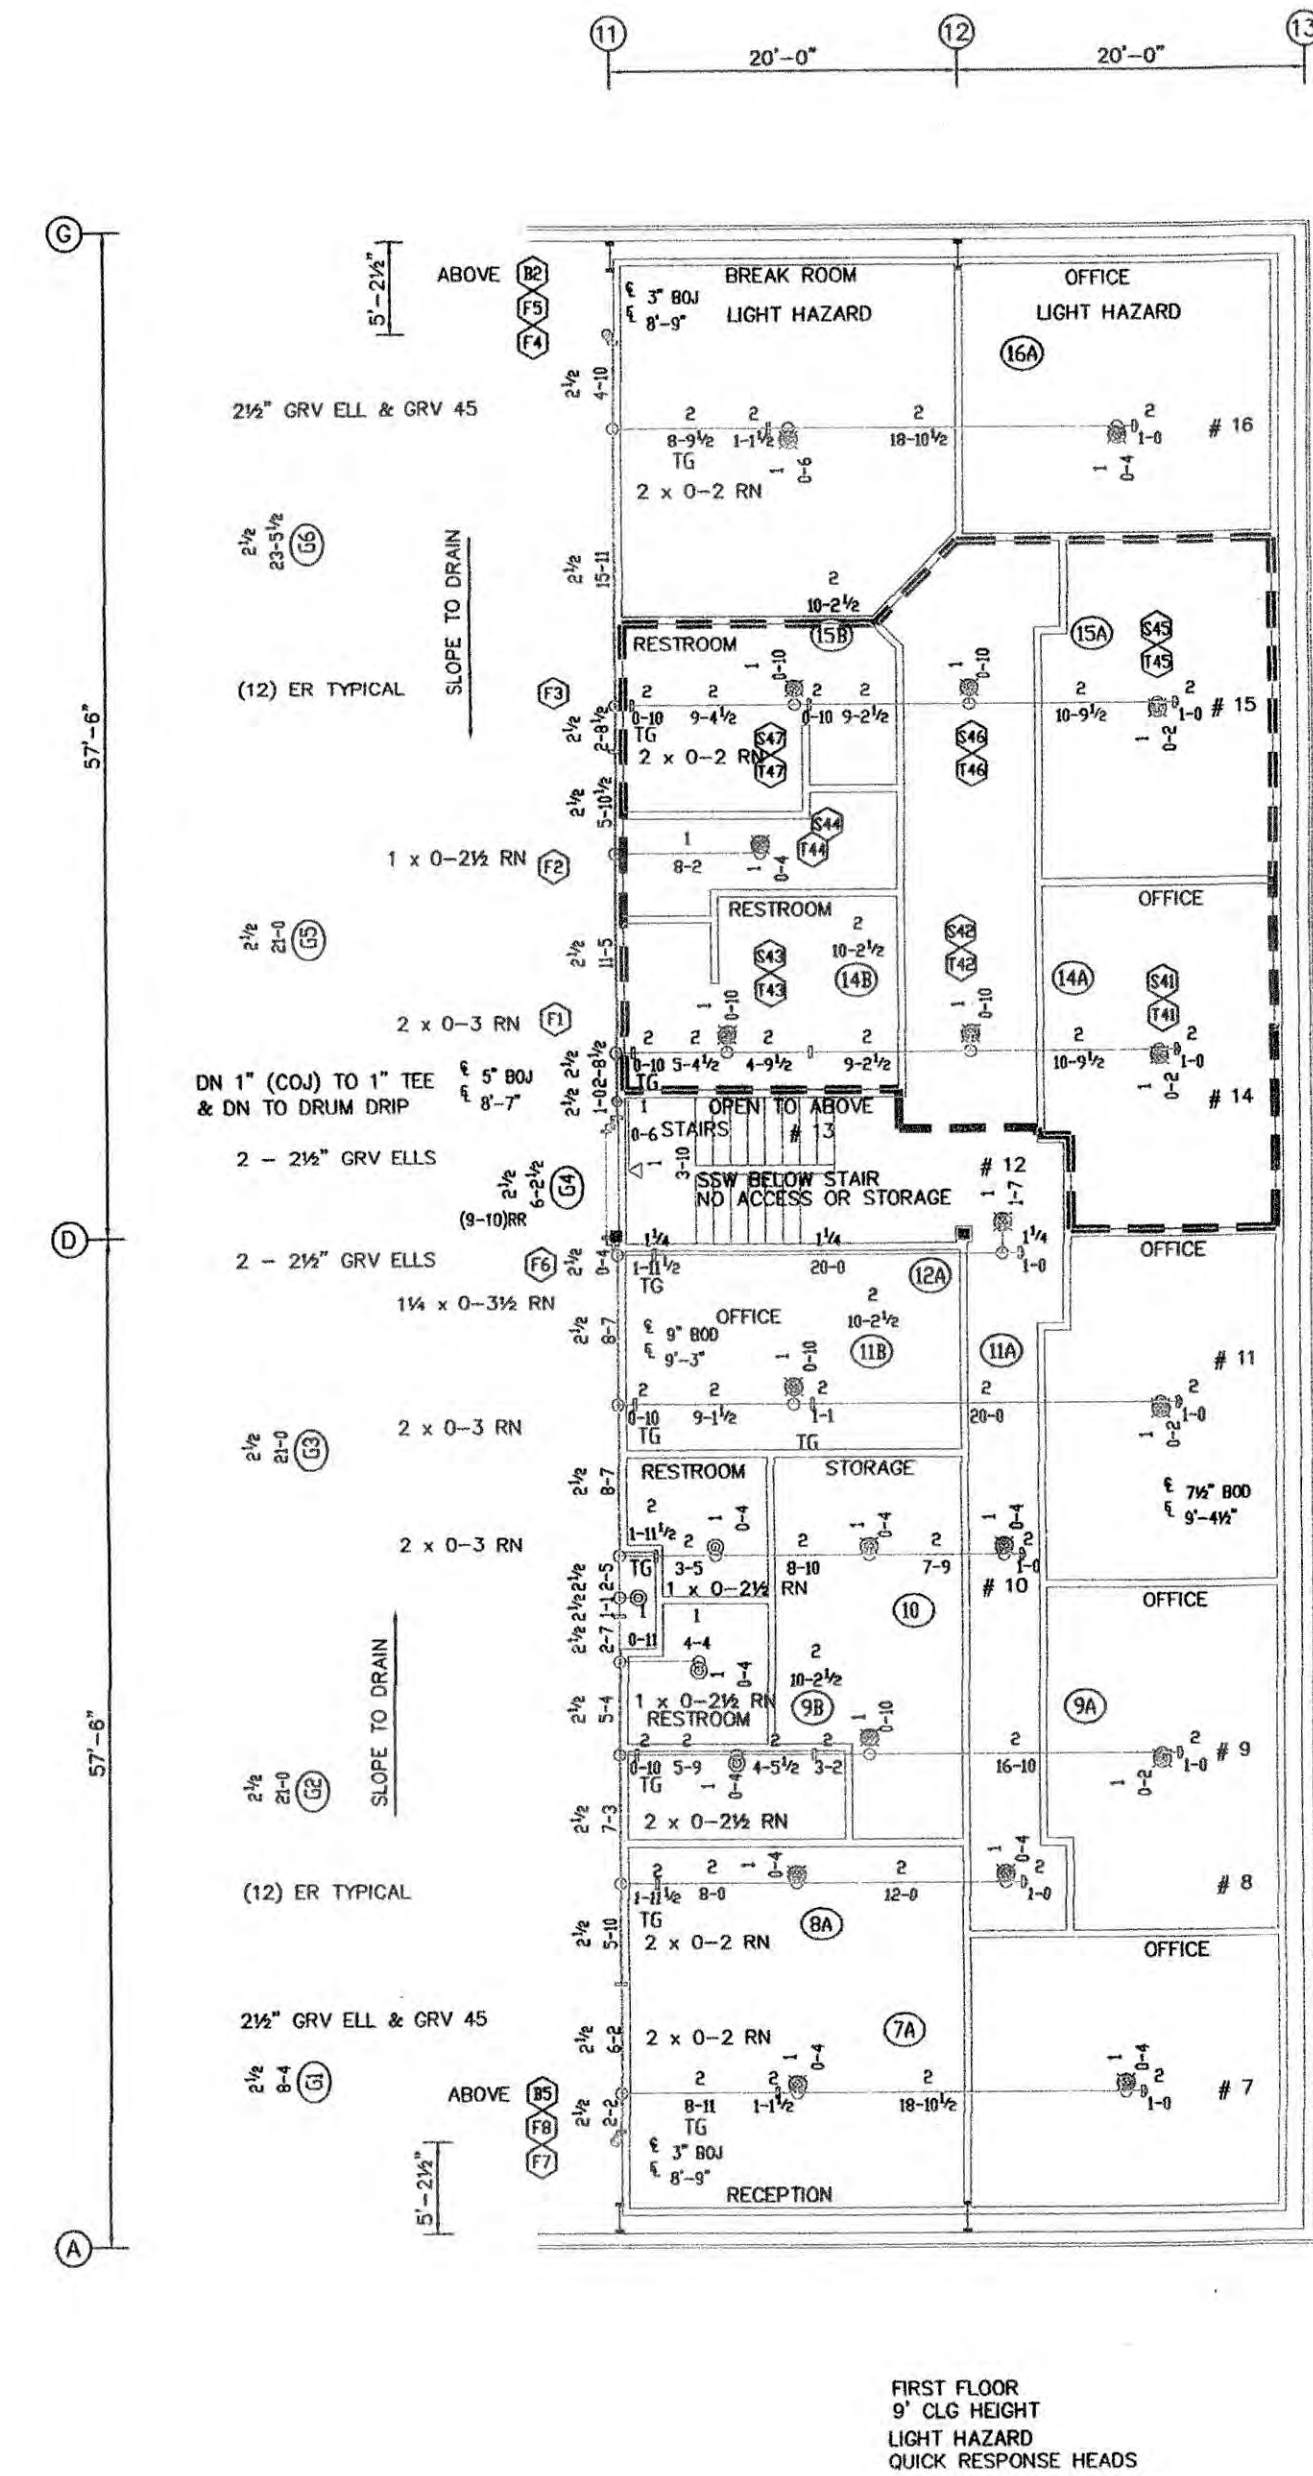


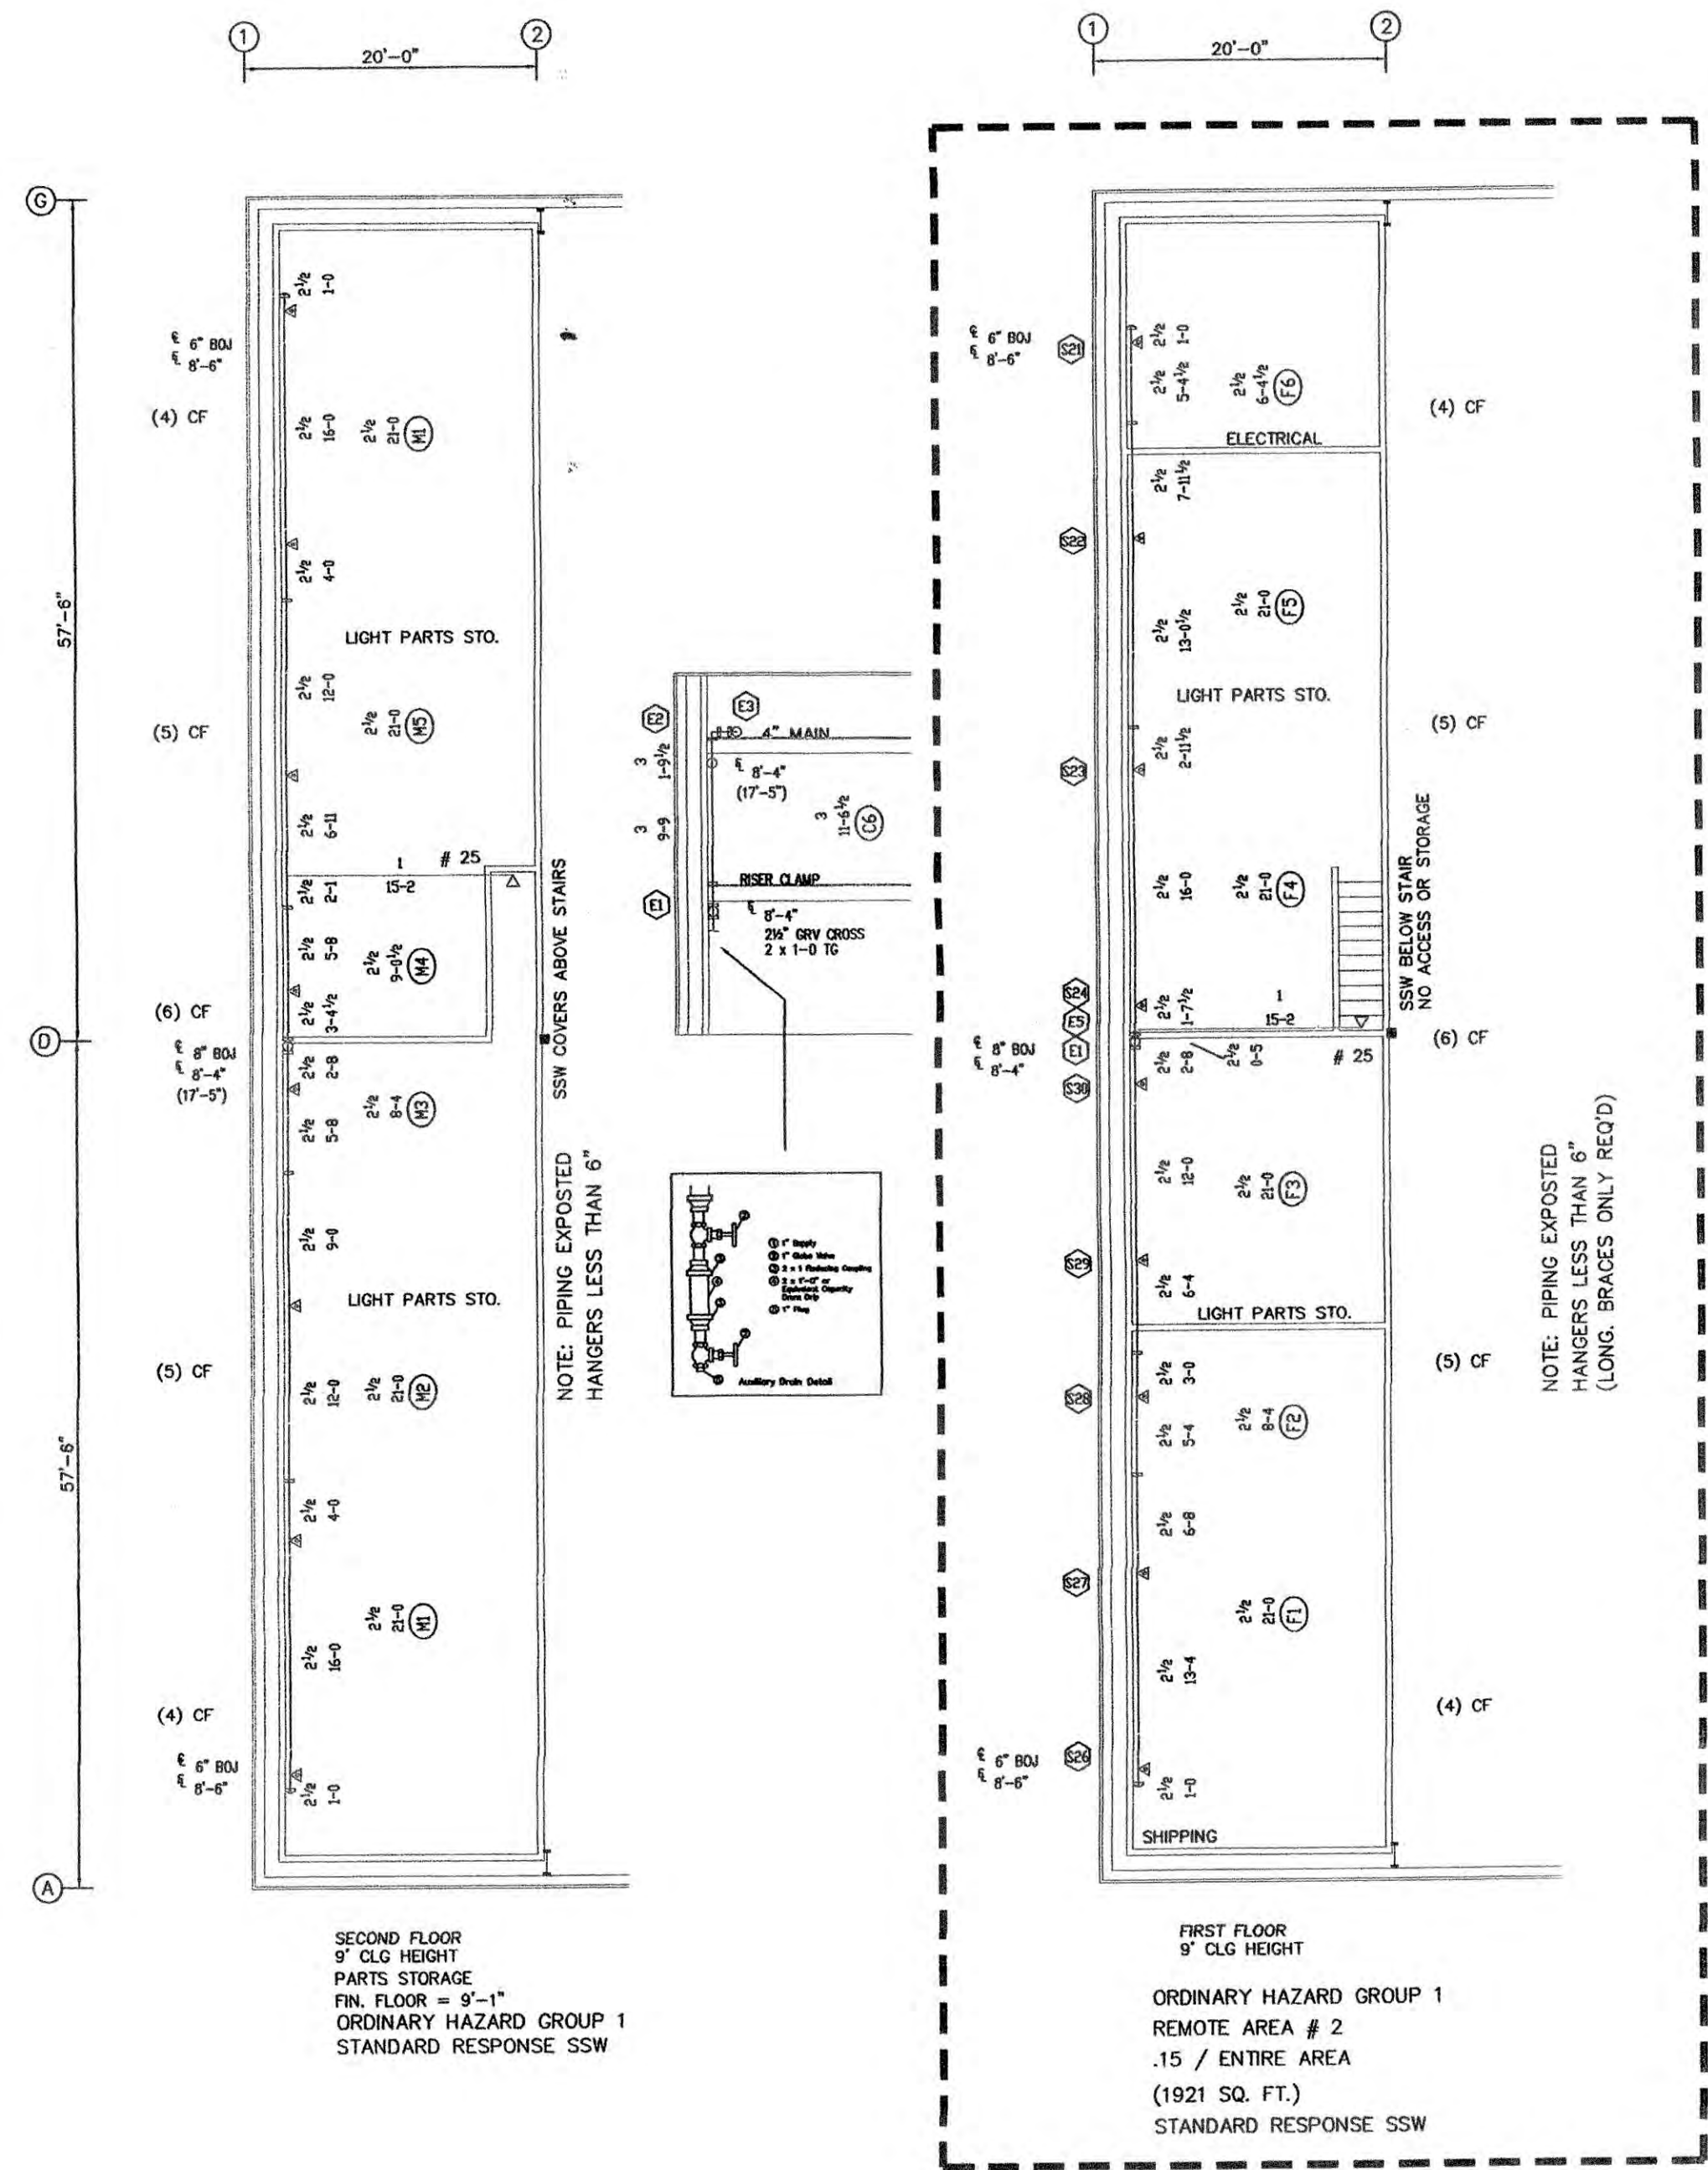




- EARTHQUAKE PROTECTION NOTES:**
1. 4 WAY BRACE INSTALLED WITHIN 2' OF TOP OF RISER
 2. LATERAL BRACE TO BE WITHIN 3' OF END OF X-MAINS
 3. LONGITUDINAL BRACE TO BE WITHIN 40' OF END OF MAINS
 4. LATERAL AND LONGITUDINAL BRACE TO BE WITHIN 2' OF CHANGE OF DIRECTION OF PIPING
 5. RISERS TO HAVE FLEXIBLE COUPLINGS AT THE TOP AND BOTTOM OF THE RISERS
 6. LOCATION FOR SEISMIC BRACING IS IN ACCORDANCE WITH NFPA AND FM STANDARDS - LOCATIONS ON DRAWINGS MAY BE SHOWN FOR CLARITY REASONS ONLY.
 7. WORST CASE EQ CALCULATIONS PROVIDED.

EQ BRACE CALC. (TYPICAL)

2 (TW) x 42' x 4.22 LBS x 5 = 88.62
4 (TW) x 21' x 11.78 LBS x 5 = 123.38
TOTAL = 212.0 LBS

BRACE INFORMATION

LENGTH OF BRACE: MAX. 13'-0"
DIA. & TYPE OF BRACE: 1 1/2" SCH. 40 PIPE
ANGLE OF BRACE: 30-45 DEGREE
LEAST RADIUS OF GYRATION: 200
L/R VALUE: 200
MAX. HORIZONTAL LOAD: 105.3 LB

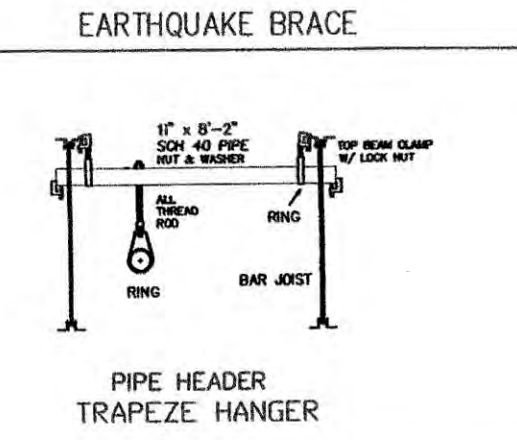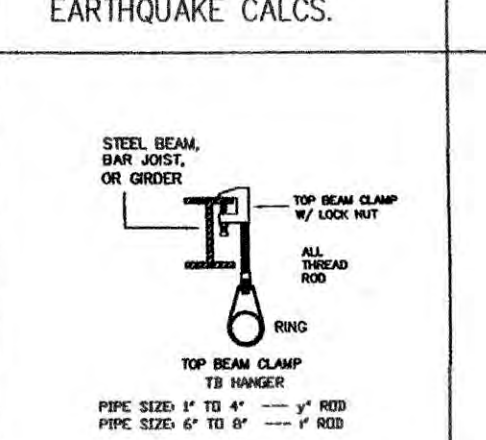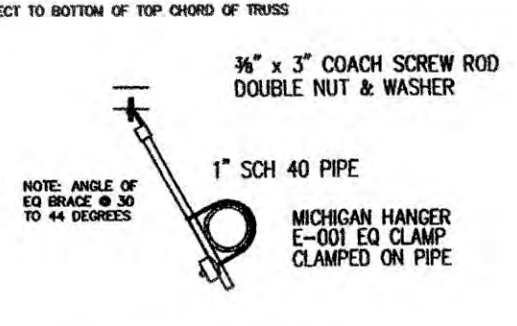

FLOW TEST INFORMATION

FLOW TEST @ CORNER PARRELL RD. @ BADGER

STATIC 60 P.S.I.
RESIDUAL 42 P.S.I.
FLOW 420 G.P.M.
PITOT 1100 G.P.M.
OUTLET SIZE 1-1/2" OUTLETS
WITNESSED BY CITY
DATE 11-26-07
ELEVATION 11-26-07

SYSTEM NUMBER: 1 REMOTE AREA NUMBER: 3
OCCUPANCY CLASSIFICATION: ORDINARY HAZARD
DENSITY: .1 AREA OF APPLICATION: 1170 SQ. FT.
NO. OF HEADS CALC'D: 13 OFFICE SIZE: K=14.0
MAX. 400 SQ. FT. PER HEAD (SSP)
SPRINKLER SYSTEM DEMAND: 296.0 GPM AT 34.84 PSI AT BASE OF RISER
HOSE STREAM REQUIRED: GPM (INSIDE) 250 GPM (OUTSIDE)
TOTAL WATER REQUIRED: 396.0 GPM AT 37.70 PSI AT CITY CORN.
PRESSURE AVAILABLE: 51.68 PSI 13.97 PSI SAFETY FACTOR

SYSTEM NUMBER: 1 REMOTE AREA NUMBER: 2
OCCUPANCY CLASSIFICATION: ORDINARY HAZARD
DENSITY: .15 AREA OF APPLICATION: 1920 SQ. FT.
NO. OF HEADS CALC'D: 13 OFFICE SIZE: K=11.2
MAX. 320 SQ. FT. PER HEAD (SSP)
SPRINKLER SYSTEM DEMAND: 423.9 GPM AT 40.33 PSI AT BASE OF RISER
HOSE STREAM REQUIRED: GPM (INSIDE) 250 GPM (OUTSIDE)
TOTAL WATER REQUIRED: 473.9 GPM AT 43.44 PSI AT CITY CORN.
PRESSURE AVAILABLE: 51.14 PSI 7.69 PSI SAFETY FACTOR

- GENERAL NOTES**
1. DESIGN ORDINARY HAZARD - 2 / 1500 SQ. FT. ADJUST 30% (1950 SQ. FT.) FOR DRY PIPE SYSTEM - BUILDING USED FOR TRUCK REPAIR
 2. MAIN PIPING TO BE THINWALL SCH. 10 PIPE WITH GROOVED FITTINGS.
 3. BRANCH LINE PIPING TO BE SCH. 10 PIPE WITH GROOVED / WELDED FITTINGS.
 4. SYSTEM TO BE IN ACCORDANCE WITH NFPA # 13.
 5. MAXIMUM STORAGE HEIGHT TO BE 12' PALLETIZED THROUGHOUT BUILDING. (IF FUTURE RACK STORAGE IS TO BE INSTALLED, STORAGE HEIGHT WILL BE LIMITED TO 12' FOR UP TO CLASS III COMMODITY AND 10' FOR CLASS IV COMMODITY)
 6. ALL UNDERGROUND PIPING (BY OTHERS) TO BE INSTALLED, BLOCKED, RODDED, FLUSHED, AND TESTED IN ACCORDANCE WITH NFPA # 13 & # 24 & # 25.
 7. SYSTEM TO BE TESTED AT 200 # FOR 2 HOURS.
 8. SEE NOTES ON SPRINKLER DESIGN
 9. BUILDING CONSTRUCTION IS STEEL BEAMS WITH METAL ROOF DECK.
 10. THERE ARE TO BE NO COMBUSTIBLES ABOVE DROPPED CEILINGS.
 11. ALL DROPS TO SSP ARE 1" FLEX DROP + 1" O" ON RETURN BENDS (OFFICE)
 12. OWNER TO PROVIDE ADEQUATE HEAT IN OFFICE AREAS TO PREVENT FREEZING.
 13. OWNER TO PROVIDE ROOM AROUND RISER WITH HEATING AND LIGHTING.

- DESIGN DEFINITIONS FROM NFPA 13 2002 EDITION:**
1. ORDINARY HAZARD GROUP II: NFPA 5.3.2 "OCCUPANCIES SHALL BE DEFINED AS OCCUPANCIES OR PORTIONS OF OCCUPANCIES WHERE THE QUANTITY AND COMBUSTIBILITY OF CONTENTS ARE MODERATE TO HIGH, STOCKPILES DO NOT EXCEED 12' AND FIRES WITH MODERATE TO HIGH RATES OF HEAT RELEASE ARE EXPECTED"
 2. NFPA 5.3.2 GIVES EXAMPLES OF ORD. HAZARD GROUP II AS:
CEREAL MILL, ORDINARY CHEMICAL PLANTS, DRY CLEANERS, HORSE STABLES, LEATHER GOODS MGN., MACHINE SHOPS, METAL WORKING, MERCANTILE, PRINTING, AND PUBLISHING (TYPICAL) OTHER THAN THOSE MENTIONED ABOVE WILL NEED TO BE VERIFIED BY FIRE MARSHALL AS AN ORDINARY HAZARD OCCUPANCY.
 3. ANY APPLICATION (TYPICAL) OTHER THAN THOSE MENTIONED ABOVE WILL NEED TO BE VERIFIED BY FIRE MARSHALL AS AN ORDINARY HAZARD OCCUPANCY.
 4. THE SPRINKLER SYSTEM FOR THIS BUILDING IS DESIGNED AND INSTALLED IN ACCORDANCE TO THE CURRENT (ADOPTED) EDITIONS OF NFPA.

UNDERGROUND LAYOUT (NTS)

8" x 20' +/-

NOTE: OWNER TO PROVIDE VALVE HOUSE AROUND NEW CONNECTION WITH HEAT AND LIGHTING AND ALSO A PUMP HOUSE WITH HEAT AND LIGHTING AROUND THE EXISTING PUMP.

CONNECT TO EXISTING 8" TEE

APPROX. 900' OF 8" PIPE TO EXISTING PUMP CONNECTED TO POND

FLOW TEST TAKEN BY TRUCK WASH

NOTE: WATER SUPPLY COMES FROM A PRIVATE INDUSTRIAL SOURCE

**REGISTERED PROFESSIONAL ENGINEER
11475
OREGON
JEE LEE LOCKWOOD
EXPIRES: 12-31-07**

SYMBOLS		REVISIONS		SPRINKLER SYMBOL DESCRIPTION										
SYMBOL	MAKE	STYLE	MP	COLOR	ORIFICE	MODEL	TEMP	K-FACTOR	TOTAL					
4-26-08 STOCKLIST CHANGES														
7-21-08 AS PER REVIEW LETTER														
Y = 2" PIPE STAND														
6 = MAIN PIPE NUMBER														
1 = CONDUIT OF PIPE														
2 = ELEVATION OF PIPE AT HANGER LOCATION														
3 = TOP OF ROOF (FEET)														
4 = BOTTOM OF CONCRETE DECK														
5 = 2 WAY EARTHQUAKE BRACE														
6 = 4 WAY EARTHQUAKE BRACE														
PERMIT # BLD2008-00464														
TAX LOT # 3201-040-00805														
OWNER: HEDGES CREEK MANAGEMENT, LLC														
14650 NW RISK CREEK ROAD PORTLAND, OREGON 97218														
TOTAL SPRINKLERS SHOWN ON THIS SHEET										64				
TOTAL SPRINKLERS REQUIRED ON THIS CONTRACT										305				

AMERICAN SPRINKLERS, INC.
7950 N. LONE PINE ROAD
(541) 584-0837 (503) 289-3955 PORTLAND
(541) 504-4244 FAX (503) 289-3955 PORTLAND FAX
(541) 948-8679 CELL PHONE
TERREBONNE, OREGON 97760

PROJECT HEDGES CREEK MANAGEMENT
TRUCK STOP
33619 E. CROWN ZELLERBACH RD.
SCAPOOSE, OREGON

SHEET TITLE OFFICE AREAS
FIRE SPRINKLER PLAN

DATE 5-3-08
SCALE 1/8" = 1'-0"
JOB NO. 2008-007
BY: C. HEDGES
CHECKED: J. LEE LOCKWOOD
DATE: 12-31-07
PAGE 2 OF 2